


GROUND FLOOR PLAN

SCALE 1:100 @ A1, 1:200 @ A3

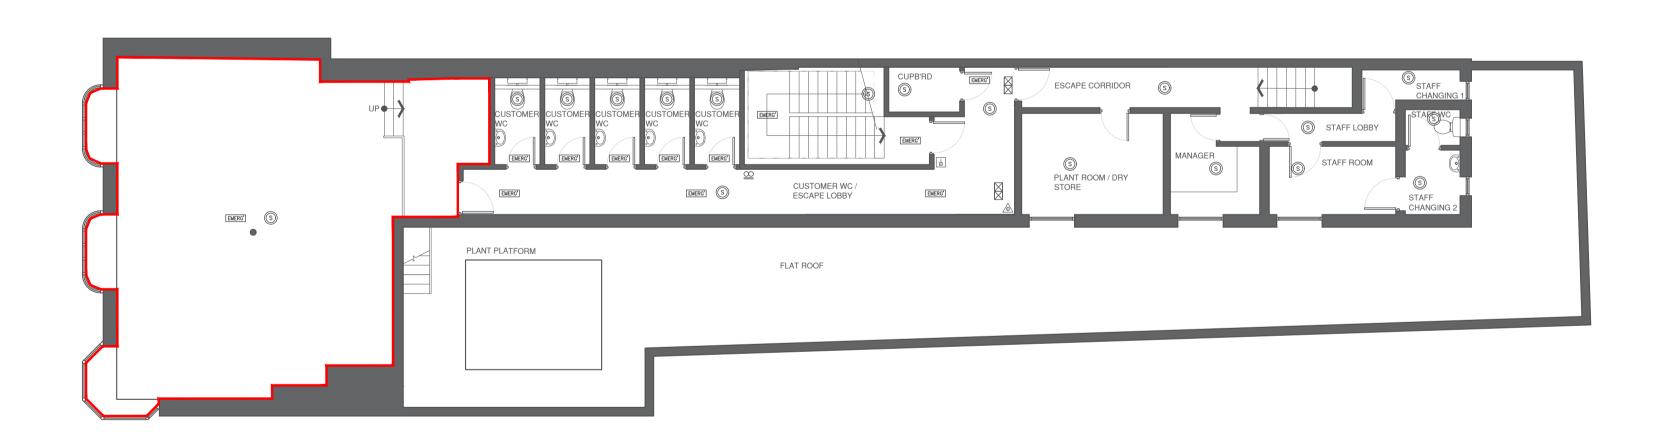

FIRST FLOOR PLAN
SCALE 1:100 @ A1, 1:200 @ A3

LICENSING KEY	
KEY	DESCRIPTION
	3HR MAINTAINED ILLUMINATED EMERGENCY EXIT SIGN.
S	SMOKE DETECTOR.
EMERG'	EMERGANCY LIGHT
Ш	FIRE ALARM BREAK GLASS POINT.
<u></u>	FIRE BELL.
	FIRE BLANKET IN CONTAINER.
	9 LITRE WATER EXTINGUISHER.
	THIS AREA IS WHERE LICENSABLE ACTIVITIES WILL TAKE PLACE. THE LOCATION & TYPE OF ANY FIRE SAFETY & ANY OTHER EQUIPMENT IS SHOWN AS PRESENT. THIS MAY BE VARIED FROM TIME TO TIME WITH THE AGREEMENT OF THE FIRE OFFICER OR AFTER A FIRE RISK ASSESSMENT.



Copyright of this drawing is owned by Focus Design Ltd - Do not reproduce, distribute without written consent. All dimensions to be checked on site and any discrepancies notified prior to commencement of work. FOCUS DESIGN Ltd 10 ST CLEMENTS STREET, WINCHESTER, SO23 9HH 01962 850000

Origin: □ CAD □ IMAGE
Status: □ For Information □ For Tender ☐ For Construction ☐ As Built Drawing DATES REV COMMENTS

CLIENT: SCALE: 1:100 @ A1, 1:200 @ A3 DATE: OCT '25 DRAWN BY : JAH

PROJECT: PIZZA EXPRESS

PETERBOROUGH PX62 25 L01 8 CATHEDRAL SQUARE PETERBOROUGH PE1 1XH

Α

DRAWING TITLE : LICENSING PLAN GROUND & FIRST FLOOR